


1 High Voltage Transformer Plan
Scale 1:50 @ A1




1:10	0	100mm	200mm	300mm	400mm	500mm	600mm	700mm	800mm	900mm	1m
1:20	0	0.5m	1m	1.5m	2m	2.5m	3m	3.5m	4m	4.5m	5m
1:25	0	0.5m	1m	1.5m	2m	2.5m	3m	3.5m	4m	4.5m	5m
1:50	0	1m	2m	3m	4m	5m	6m	7m	8m	9m	10m
1:100	0	1m	2m	3m	4m	5m	6m	7m	8m	9m	10m
1:200	0	5m	10m	15m	20m	25m	30m	35m	40m	45m	50m
1:250	0	5m	10m	15m	20m	25m	30m	35m	40m	45m	50m
1:500	0	10m	20m	30m	40m	50m	60m	70m	80m	90m	100m
1:1000	0	10m	20m	30m	40m	50m	60m	70m	80m	90m	100m

- Drawing Notes**
- All dimensions are shown in metres unless noted otherwise.
 - Do not scale from this drawing.

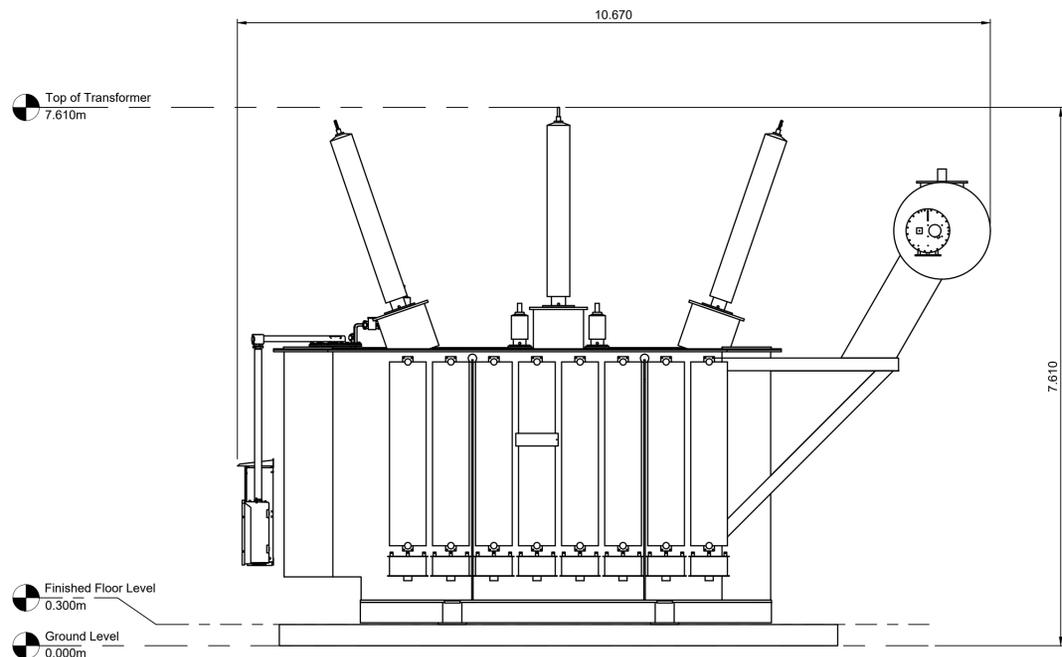

2 High Voltage Transformer South Elevation
Scale 1:50 @ A1

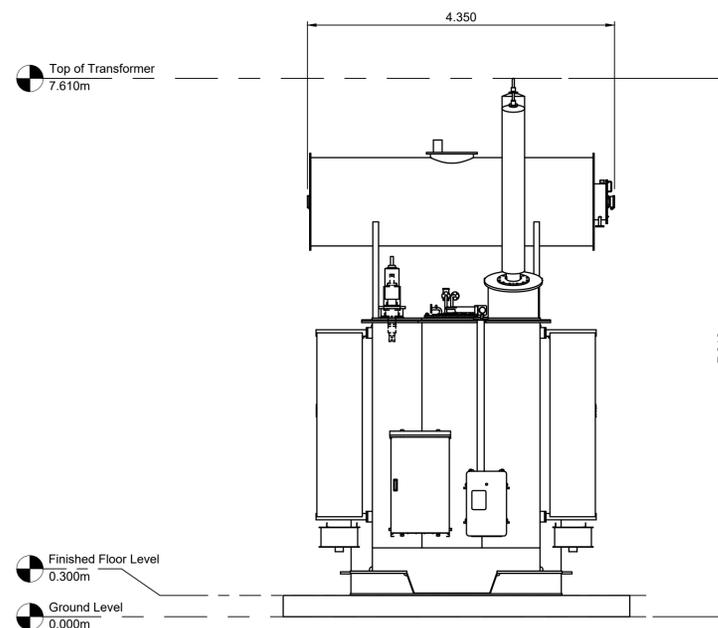

3 High Voltage Transformer West Elevation
Scale 1:50 @ A1

REV	DATE	DESCRIPTION	BY	CHKD
0	29.10.2024	High Voltage Transformer Plan and Elevations	EW	JH

FIELD
Field
Fora Montacute Yards
186 Shoreditch High Street
London
E1 6HU

PROJECT
Spittal

TITLE
High Voltage Transformer
Plan and Elevations

DISCIPLINE
PLANNING

DRAWING STATUS
FOR PLANNING

SCALE	DATE	DRAWN BY	CHECKED BY	APPROVED BY
1:50 @A1	29.10.2024	EW	JH	RS
PROJECT NO.	DRAWING NO.	REV.		
BTGBSPI01	004.5	00		